

REFLECTED CEILING PLAN SYMBOL LEGEND


- | | | |
|---|---|--|
| <p>01. CEILING MOUNTED COMPONENTS ARE SHOWN FOR COORDINATION PURPOSE ONLY. REFER TO MEP DRAWINGS FOR EXACT LOCATIONS AND ADDITIONAL REQUIREMENTS.</p> <p>02. EXISTING SPRINKLER HEADS NOT SHOWN. REFER TO MEP DRAWINGS FOR RELOCATION REQUIREMENTS.</p> | <p>□ "BOLD" SOLID LINES INDICATE NEW</p> <p>□ "DREY" SOLID LINES INDICATE EXISTING TO REMAIN</p> <p>□ "BOLD" DASHED LINES INDICATE EXISTING TO BE DEMOLISHED</p> <p>● SEM-RECESSED PENDENT SPRINKLER HEAD</p> <p>○ DRY TYPE SIDE WALL SPRINKLER HEAD</p> <p>▽ SIDEWALL SPRAY HEAD</p> <p>○ UPRIGHT SPRINKLER HEAD</p> <p>□ EMERGENCY LIGHT BATTERY PACK/ TWO HEAD UNIT</p> <p>□ CEILING MOUNTED EMERGENCY LIGHT BATTERY PACK</p> <p>○ SMOKE DETECTOR, CEILING OR WALL MOUNTED</p> <p>○ HEAT DETECTOR, CEILING OR WALL MOUNTED</p> <p>○ FIRE ALARM VISUAL DEVICE</p> | <p>□ WALL MOUNTED FIRE ALARM PULL STATION</p> <p>□ FIRE ALARM AUDIO/VISUAL DEVICE</p> <p>○ CEILING MOUNTED OCCUPANCY SENSOR</p> <p>□ WALL OR CEILING MOUNTED EXIT SIGN, SINGLE FACE. ARROW WHEN USED INDICATES DIRECTION.</p> <p>□ WALL OR CEILING MOUNTED EXIT SIGN, DOUBLE FACE. ARROW WHEN USED INDICATES DIRECTION.</p> <p>□ AIR DIFFUSER</p> <p>□ 2'x4 CEILING MOUNTED OR LAY-IN FLUORESCENT LIGHT FIXTURE</p> <p>□ 2'x2 CEILING MOUNTED OR LAY-IN FLUORESCENT LIGHT FIXTURE</p> <p>□ 1'x4 CEILING MOUNTED OR LAY-IN FLUORESCENT LIGHT FIXTURE</p> <p>— SUSPENDED OR SURFACE MOUNTED FLUORESCENT LIGHT FIXTURE</p> <p>+</p> <p>FLUORESCENT UP-LIGHT FIXTURE</p> |
|---|---|--|

REFLECTED CEILING PLAN DEMOLITION GENERAL NOTES

- SELECTIVE DEMOLITION WORK EXTENTS ARE APPROXIMATE. COORDINATE WITH REQUIREMENTS FOR NEW WORK. SEE MEP DRAWINGS FOR ADDITIONAL REQUIREMENTS.
- PROTECT EXISTING DRYWALL, BULKHEAD, LAY-IN CEILING, AND ALL MECHANICAL, ELECTRICAL, AND FIRE PROTECTION DEVICES & FIXTURES DURING CONSTRUCTION.

REFLECTED CEILING PLAN DEMOLITION KEY NOTES

- TEMPORARILY REMOVE A PORTION OF EXISTING LAY-IN CEILING SYSTEM (APPROX. 4'x4') INCLUDING TILES AND GRID FOR ABOVE CEILING WORK AS REQUIRED BY 2ND FLOOR FCU UNITS DEMOLITION. REFER TO MEP DRAWINGS FOR ADDITIONAL REQS. APPROXIMATE EXTENTS ARE INDICATED BY HATCH.
- DEMOLISH A PORTION OF EXISTING GYM CEILING FOR ABOVE CEILING WORK AS REQUIRED BY 2ND FLOOR FCU UNITS DEMOLITION. REFER TO MEP DRAWINGS FOR ADDITIONAL REQS. APPROXIMATE EXTENTS ARE INDICATED BY HATCH.
- DEMOLISH PORTION OF EXISTING LAY-IN CEILING SYSTEM TO THE EXTENTS REQUIRED FOR NEW CHASSES. REFER TO RENOVATION FLOOR PLAN AND RCP FOR ADDITIONAL REQS. REFER TO MEP DRAWINGS FOR ADDITIONAL DETAILS.

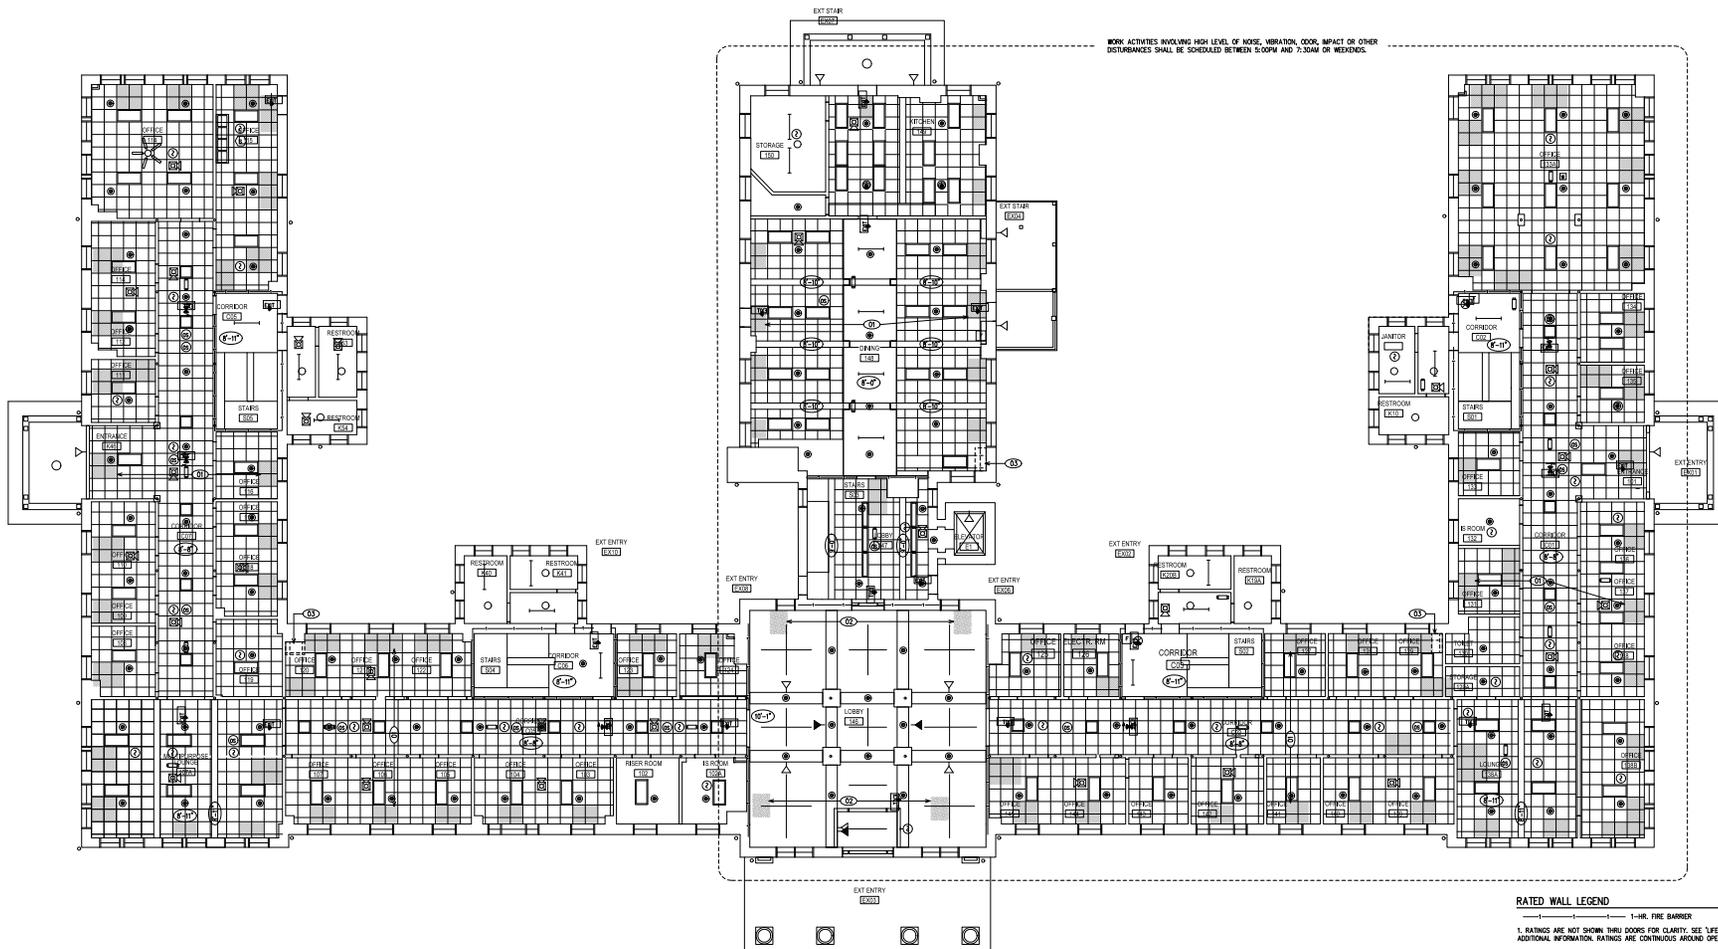

DEMOLITION FIRST FLOOR - REFLECTED CEILING PLAN
1/8" = 1'-0"

RATED WALL LEGEND

- 1-HR. FIRE BARRIER
- RATINGS ARE NOT SHOWN THRU DOORS FOR CLARITY. SEE "LIFE SAFETY PLAN" FOR ADDITIONAL INFORMATION. RATINGS ARE CONTIGUOUS AROUND OPENINGS.
 - FIRE BARRIERS AND HORIZONTAL ASSEMBLIES ARE TO BE PROTECTED AND MAINTAINED. PENETRATIONS IN THE FLOOR SLAB OR CEILING SLAB ARE TO BE RATED FOR INCLUDED UL DESIGN NUMBERS. CONSULT CONTRACTOR TO ALERT ARCHITECT IF THE FIRE BARRIERS AND HORIZONTAL ASSEMBLIES IN THE AREA OF WORK ARE NOT CONTIGUOUS OR HAVE UNEXPECTED PENETRATIONS.



Davis Kane

**WAKE COUNTY COMMUNITY SERVICE CENTER
RENOVATION - PHASE #1**
401 E. WHITAKER MILL ROAD
RALEIGH, NC 27608

© 2017 Engineered Designs, Inc.
This drawing is the property of Engineered Designs, Inc. and is not to be used for any other project without the express written consent of Engineered Designs, Inc. The user shall be held liable for any errors or omissions on this drawing.

JOB NUMBER: 090-16
DRAWN: [blank]
CHECKED: [blank]

DEMOCRAT FIRST FLOOR

D-1.3